


**Drawing is for illustrative purposes only  
 NTS Measurements are approximate  
 Vendor shall be responsible for final design**

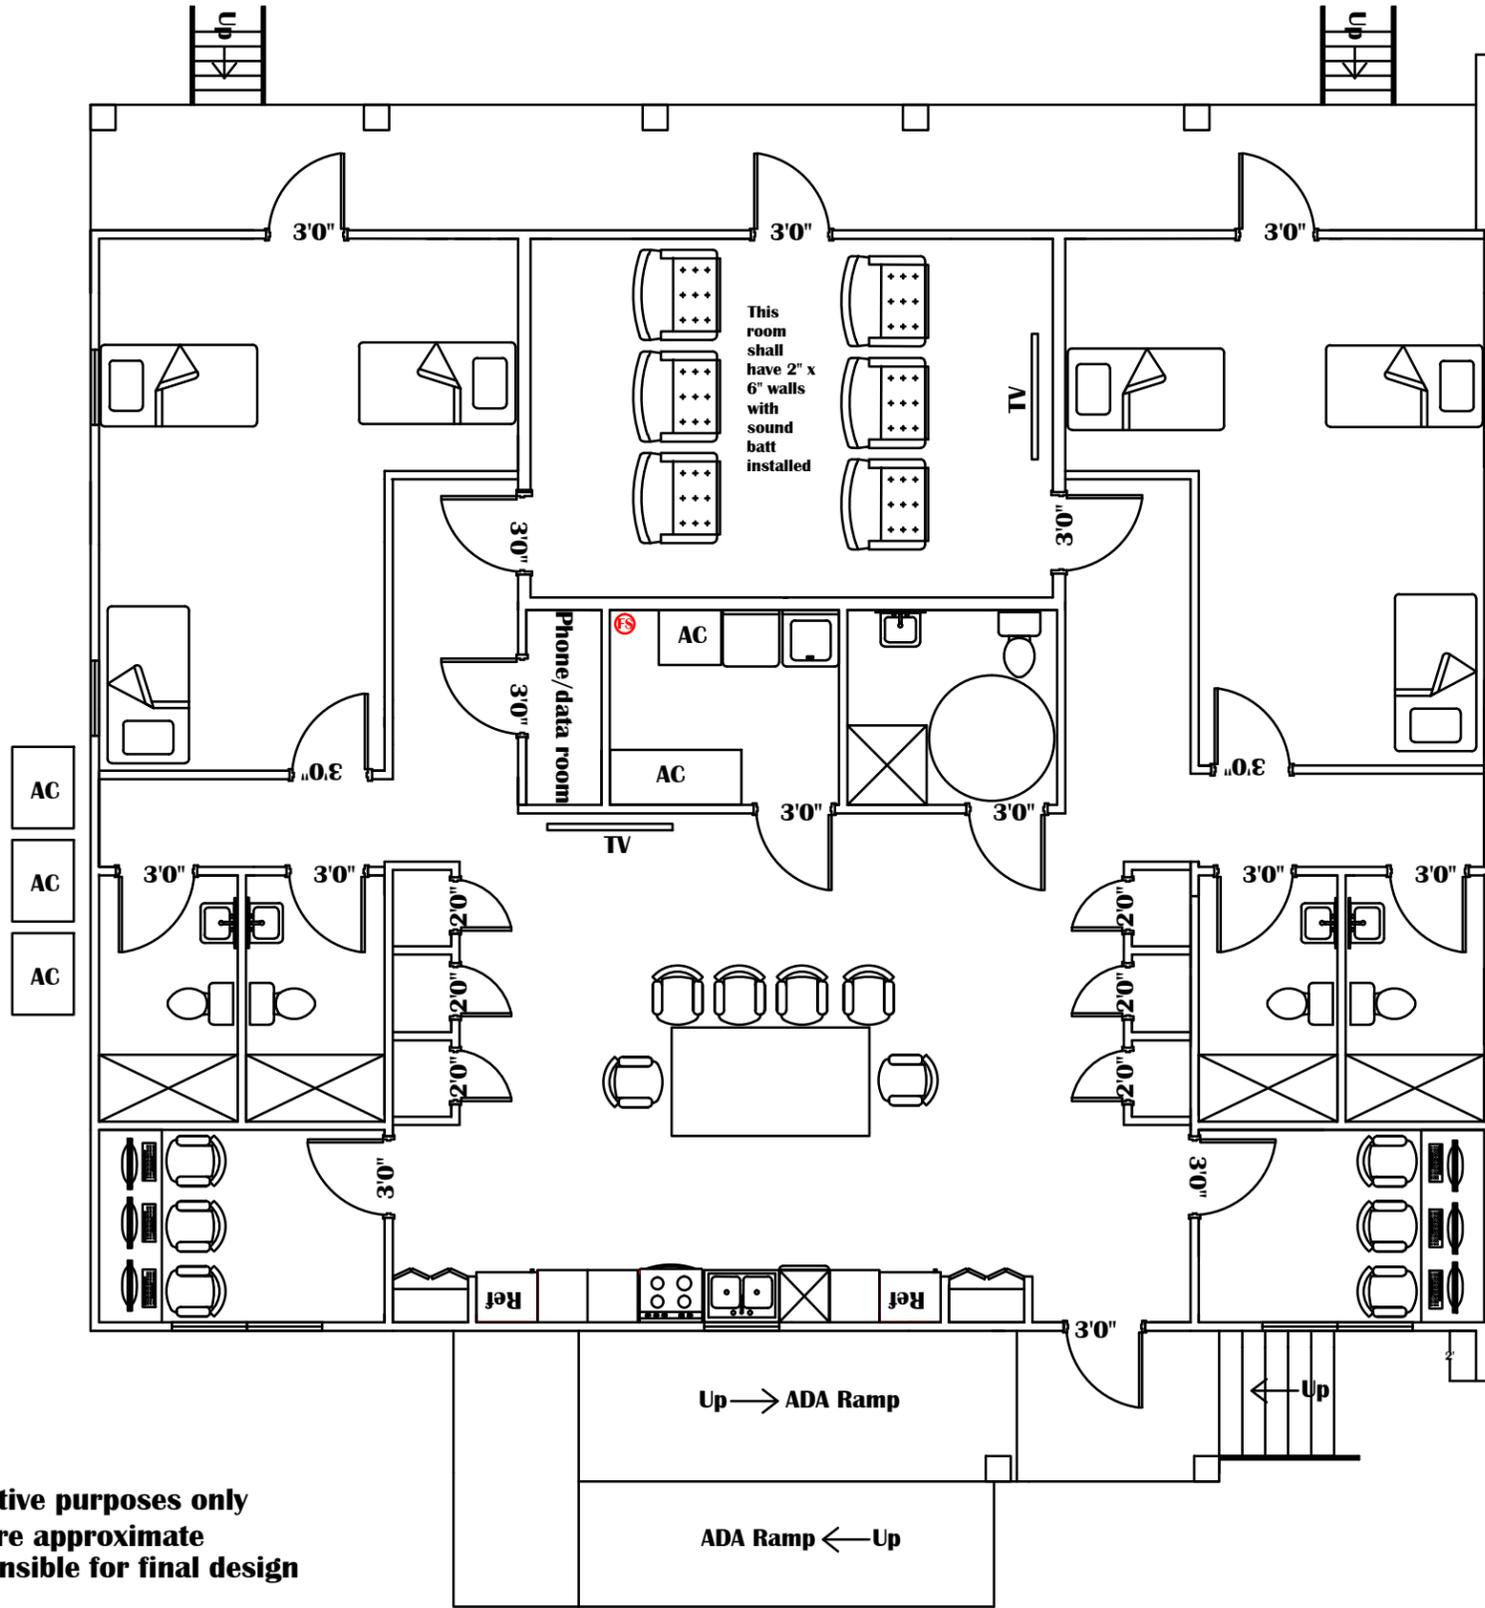

REVISIONS	
no.	date description

ISSUED FOR: **BIDDING**


Date: 5.23.14  
 Reviewed by: RLB  
 Drawn by: DMGII  
 SHEET NBR.

# FIRE STATION 90 & 104 FLOOR PLAN

Symbol Legend

	110 - volt duplex receptacle
	GFCI duplex receptacle
	240- volt receptacle
	Television jack
	Telephone & data jack
	Telephone jack
	Electric panel
	Water heater

**Drawing is for illustrative purposes only**  
**NTS Measurements are approximate**  
**Vendor shall be responsible for final design**

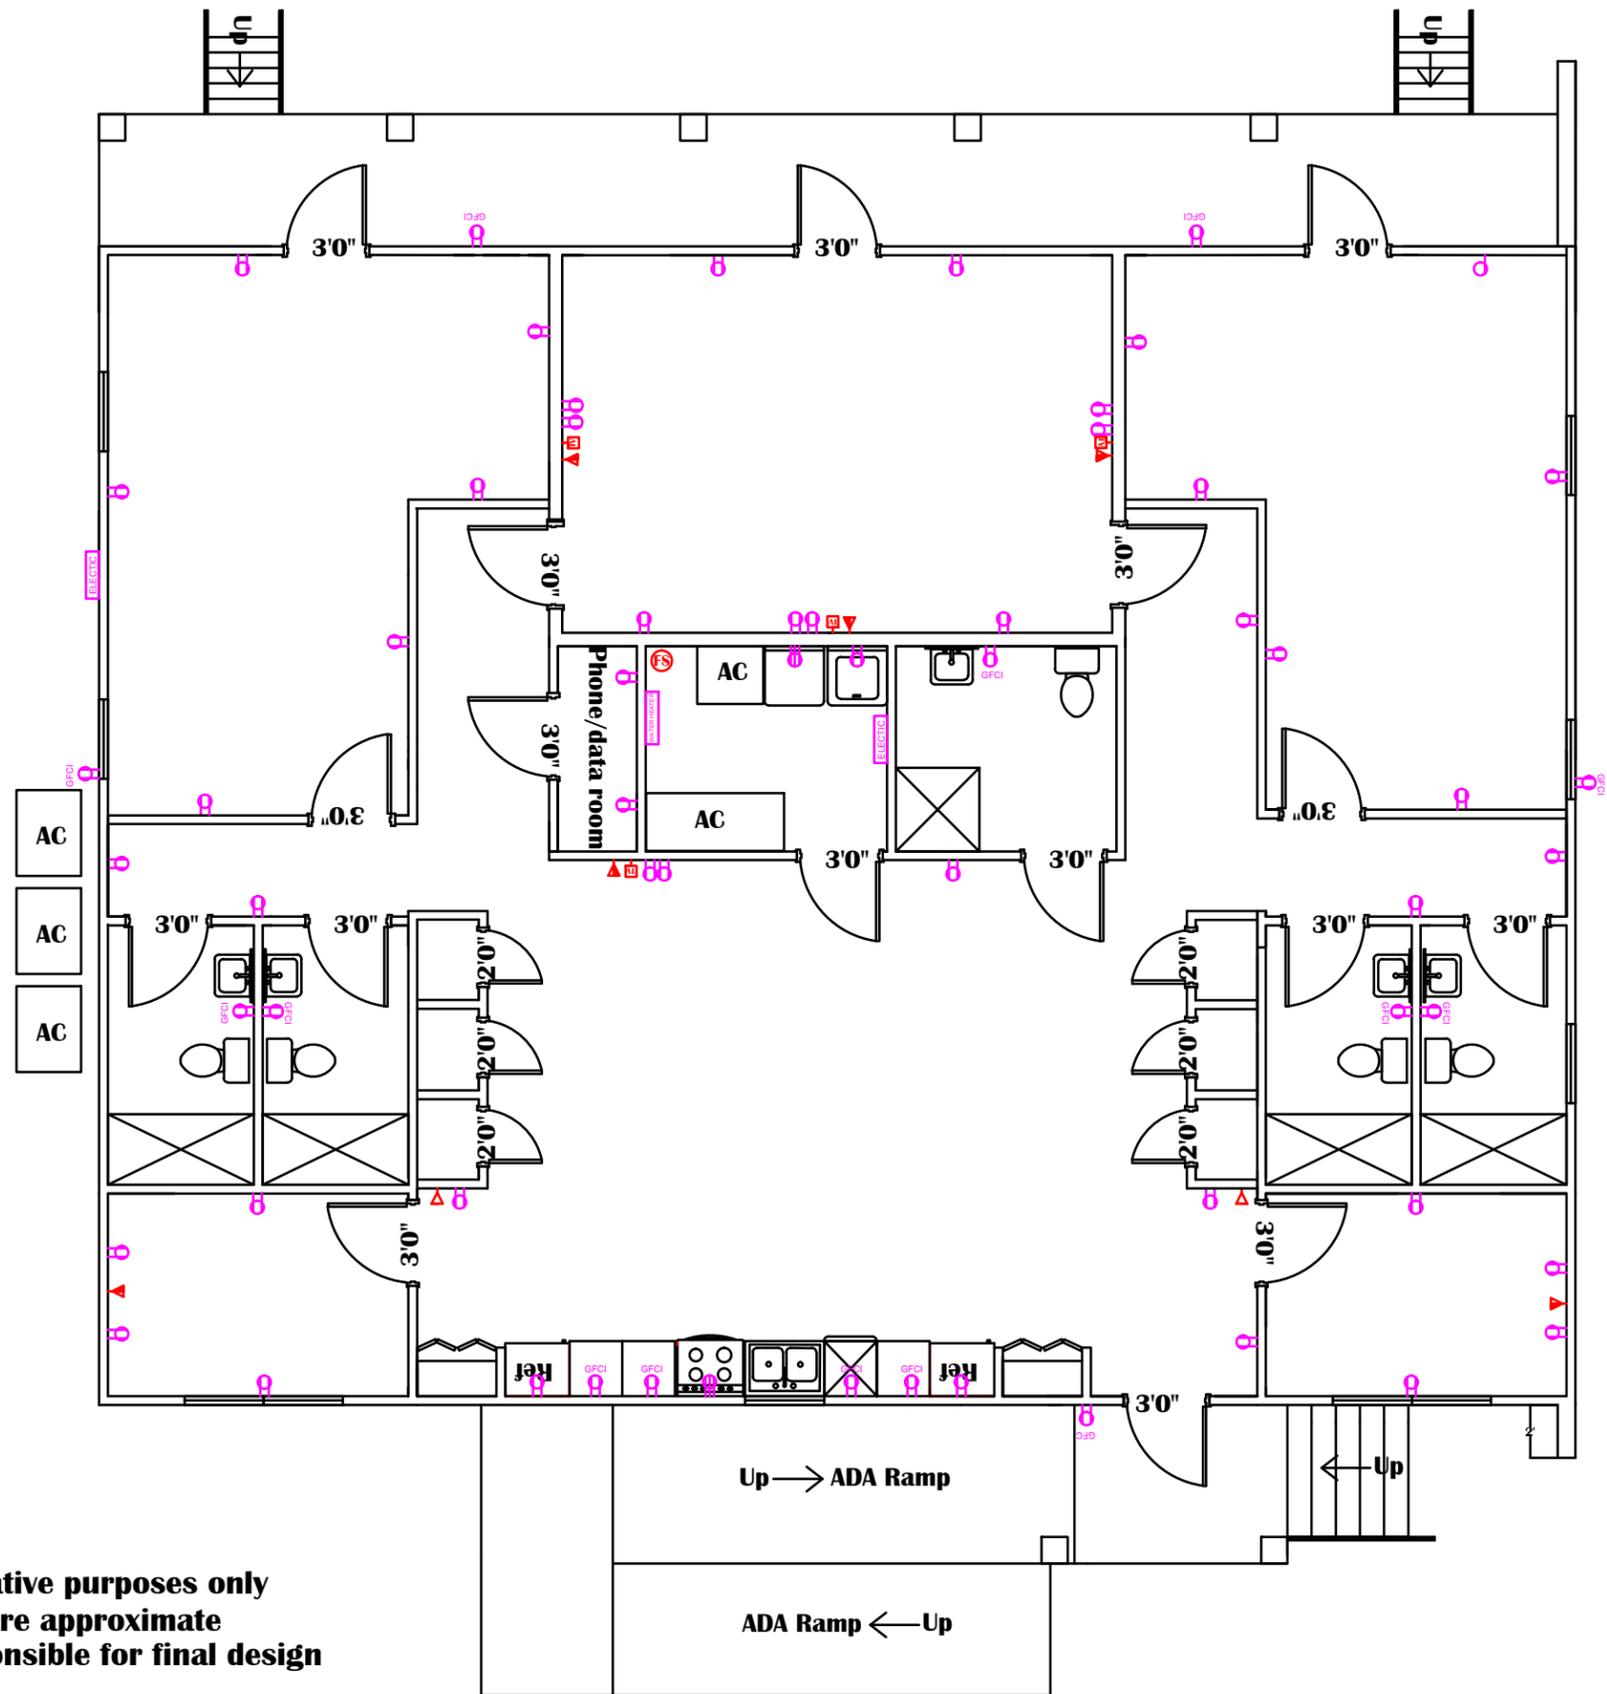

REVISIONS	
no.	date description

ISSUED FOR: **BIDDING**

Date: 5.23.14  
Reviewed by: RLB  
Drawn by: DMGII  
SHEET NBR.


**2 of 9**

# FIRE STATION 90 & 104

## ELECTRIC PLAN



Lake County Dept. of Facilities  
Development & Management  
32400 CR 473  
Leesburg, FL 34788  
352.253.4960

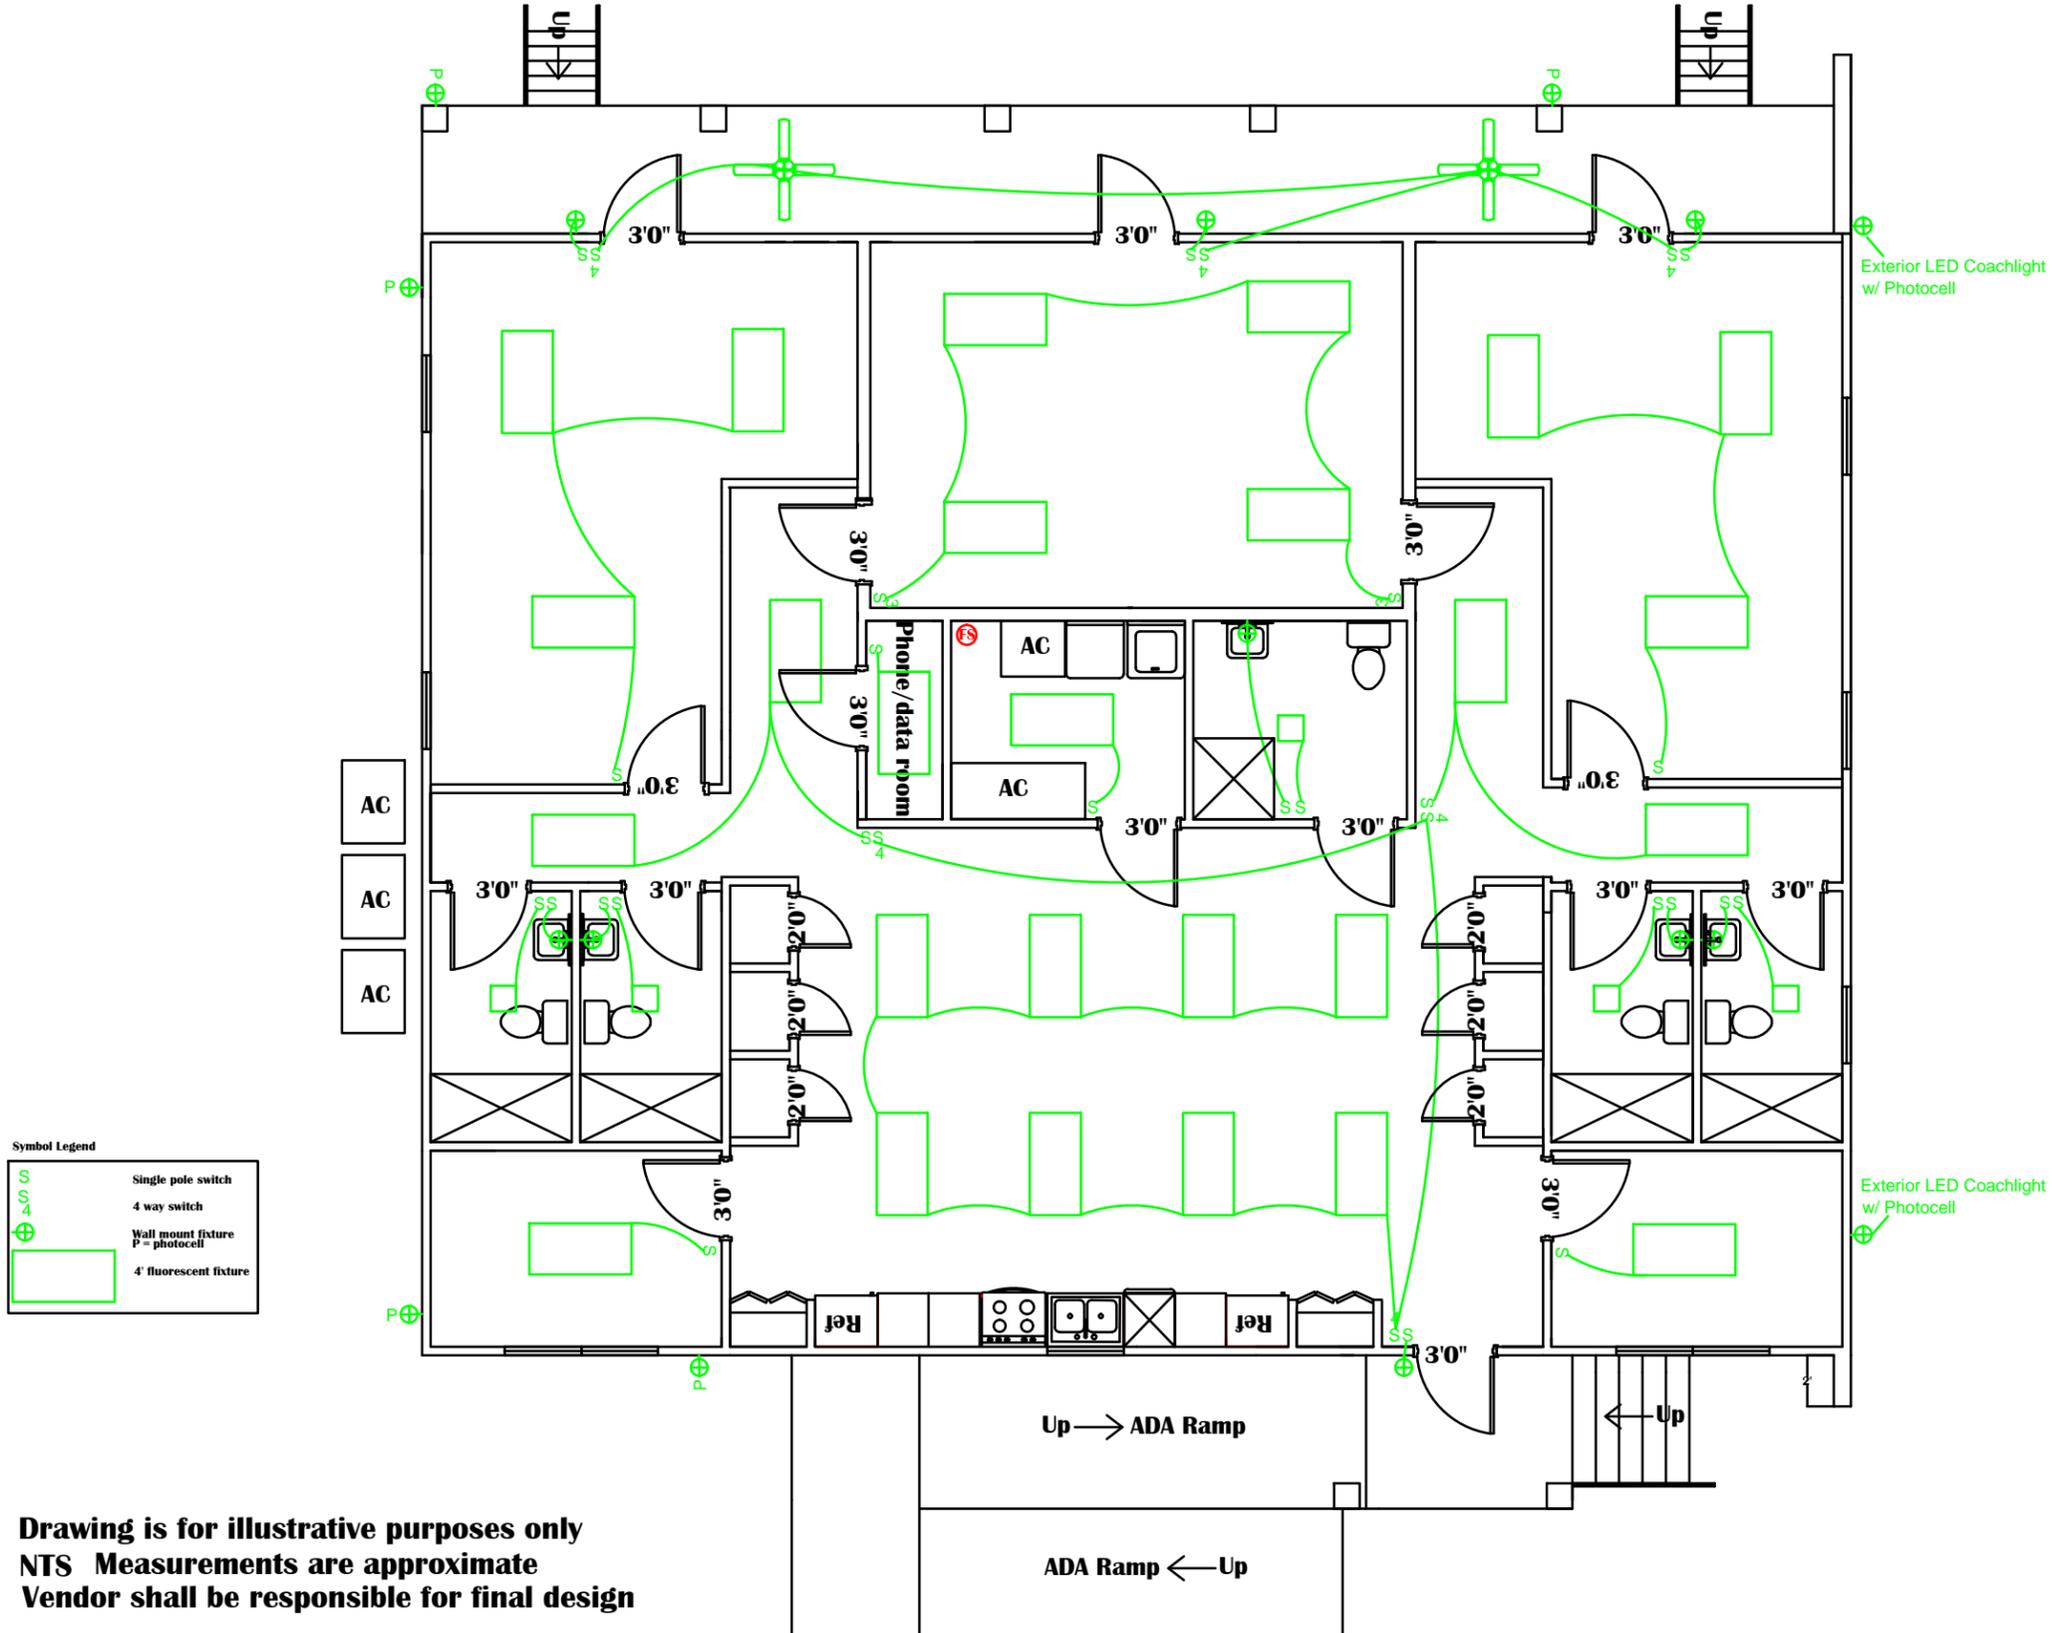

Symbol Legend

S	Single pole switch
S4	4 way switch
P	Wall mount fixture
P	photocell
[Green box]	4' fluorescent fixture

**Drawing is for illustrative purposes only**  
**NTS Measurements are approximate**  
**Vendor shall be responsible for final design**

Lake County Dept. of Facilities  
 Development & Management  
 32400 CR 473  
 Leesburg, FL 34788  
 352.253.4960

**LAKE COUNTY**  
FLORIDA

# FIRE STATION 90 & 104

## LIGHTING PLAN

REVISIONS	
no.	description

ISSUED FOR: **BIDDING**


Date: 5.23.14  
 Reviewed by: RLB  
 Drawn by: DMGII  
 SHEET NO.:

**3 of 9**

Symbol Legend

		<b>SPEAKER LOCATIONS</b>
--	--	--------------------------

**Drawing is for illustrative purposes only  
 NTS Measurements are approximate  
 Vendor shall be responsible for final design**

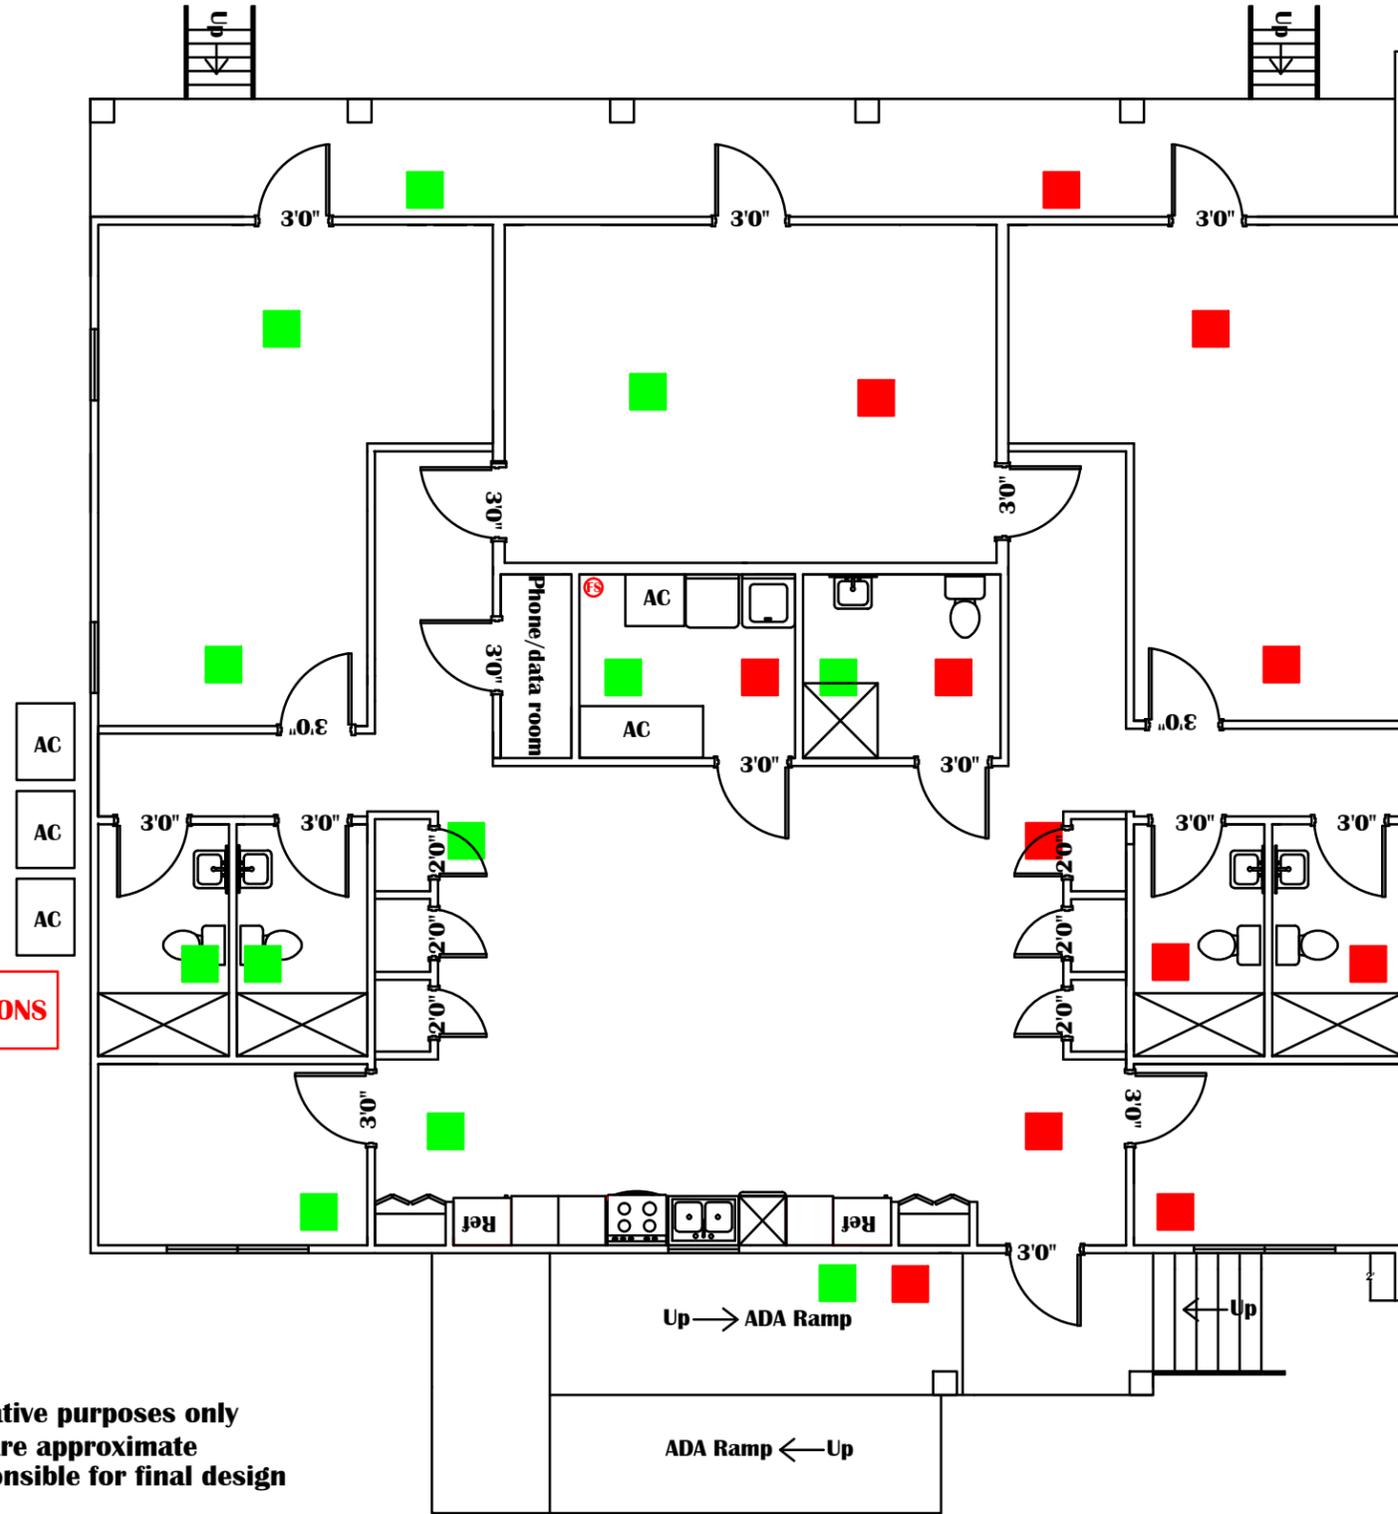

REVISIONS

no.	date	description

ISSUED FOR:	<b>BIDDING</b>
Date:	5.23.14
Reviewed by:	RLB
Drawn by:	DMGII
SHEET NBR.	<b>4 of 9</b>

# FIRE STATION 90 & 104


## DATA-RADIO PLAN



**LAKE COUNTY**  
FLORIDA

Lake County Dept. of Facilities  
 Development & Management  
 32400 CR 473  
 Leesburg, FL 34788  
 352.253.4960

Drawing is for illustrative purposes only  
 NTS Measurements are approximate  
 Vendor shall be responsible for final design

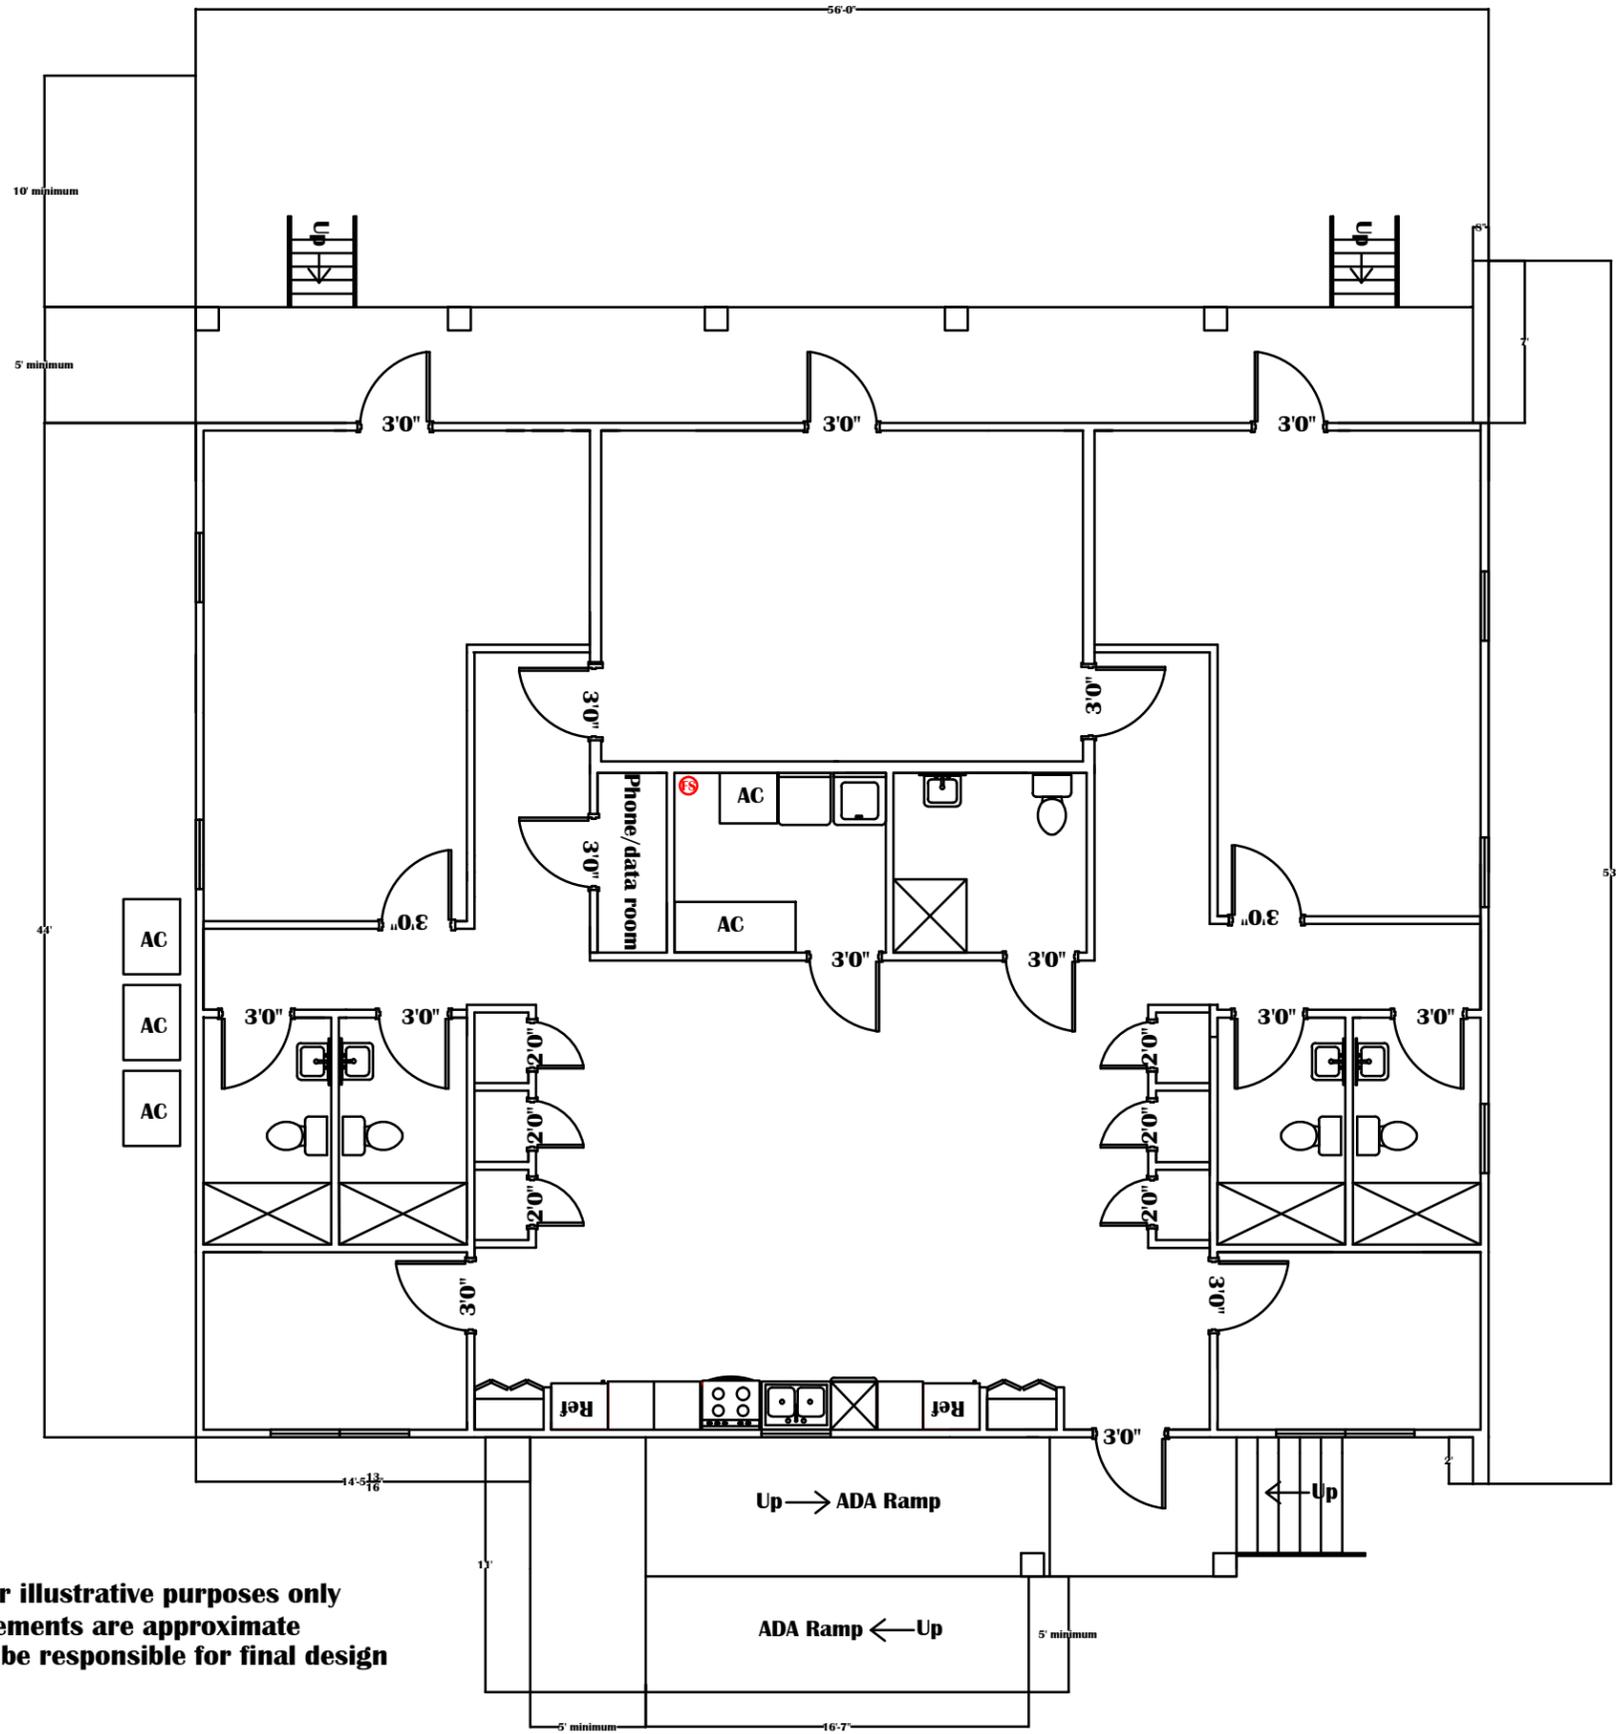

REVISIONS		no.	date	description
ISSUED FOR:				
BIDDING				


Date: 5.23.14  
 Reviewed by: RLB  
 Drawn by: DMGII  
 SHEET NBR.  
**5 of 9**

# FIRE STATION 90 & 104

## DIMENSION PLAN



Lake County Dept. of Facilities  
 Development & Management  
 32400 CR 473  
 Leesburg, FL 34788  
 352.253.4960

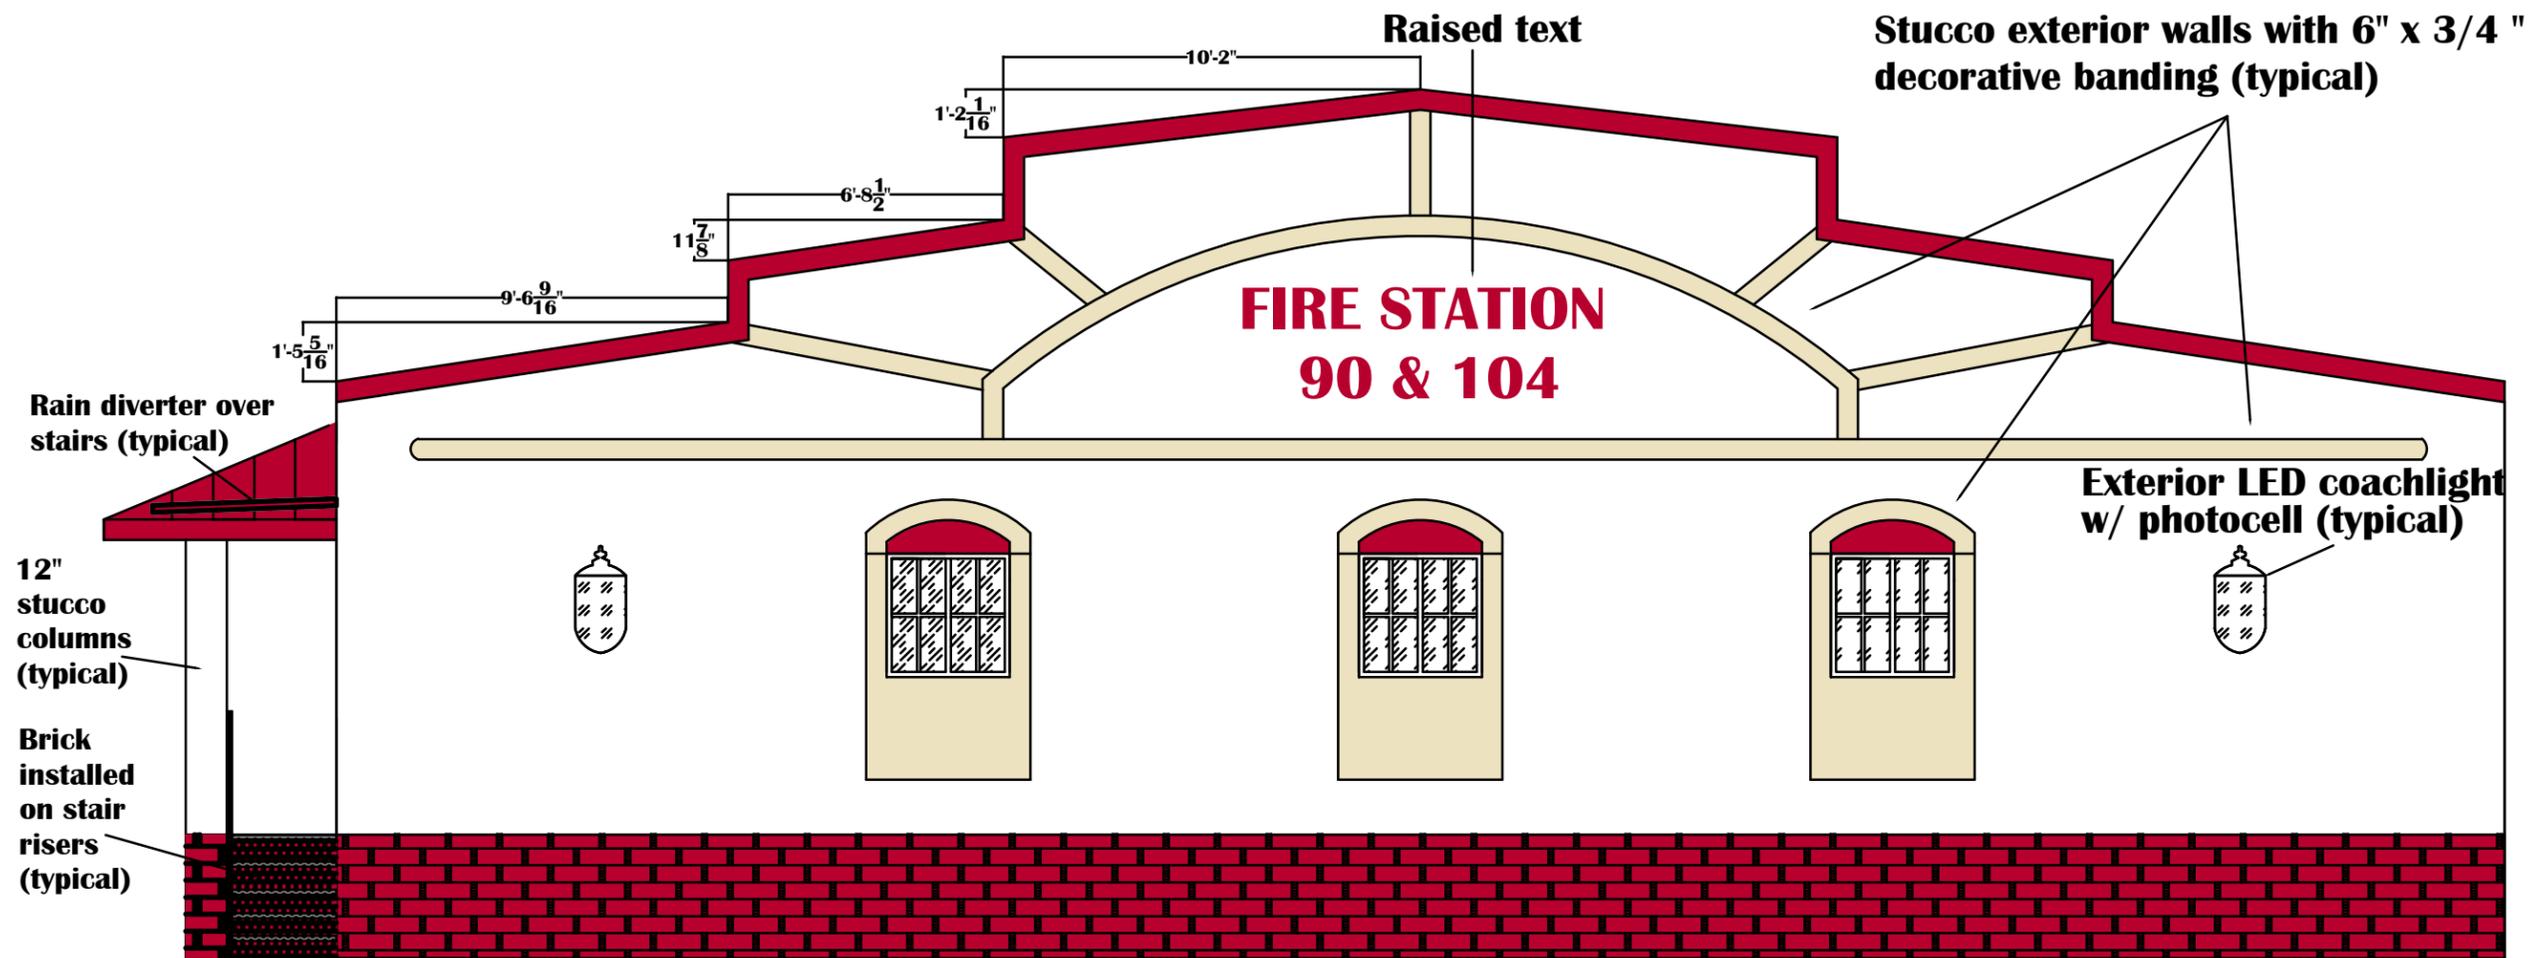


**Drawing is for illustrative purposes only**  
**NTS Measurements are approximate & minimum**  
**Vendor shall be responsible for final design**

**FIRE STATION 90 & 104**  
**FRONT ELEVATION PLAN**

REVISIONS	
no.	date description

ISSUED FOR: **BIDDING**

Date: 5.23.14  
 Reviewed by: RLB  
 Drawn by: DMGII  
 SHEET NBR.  
**6 of 9**

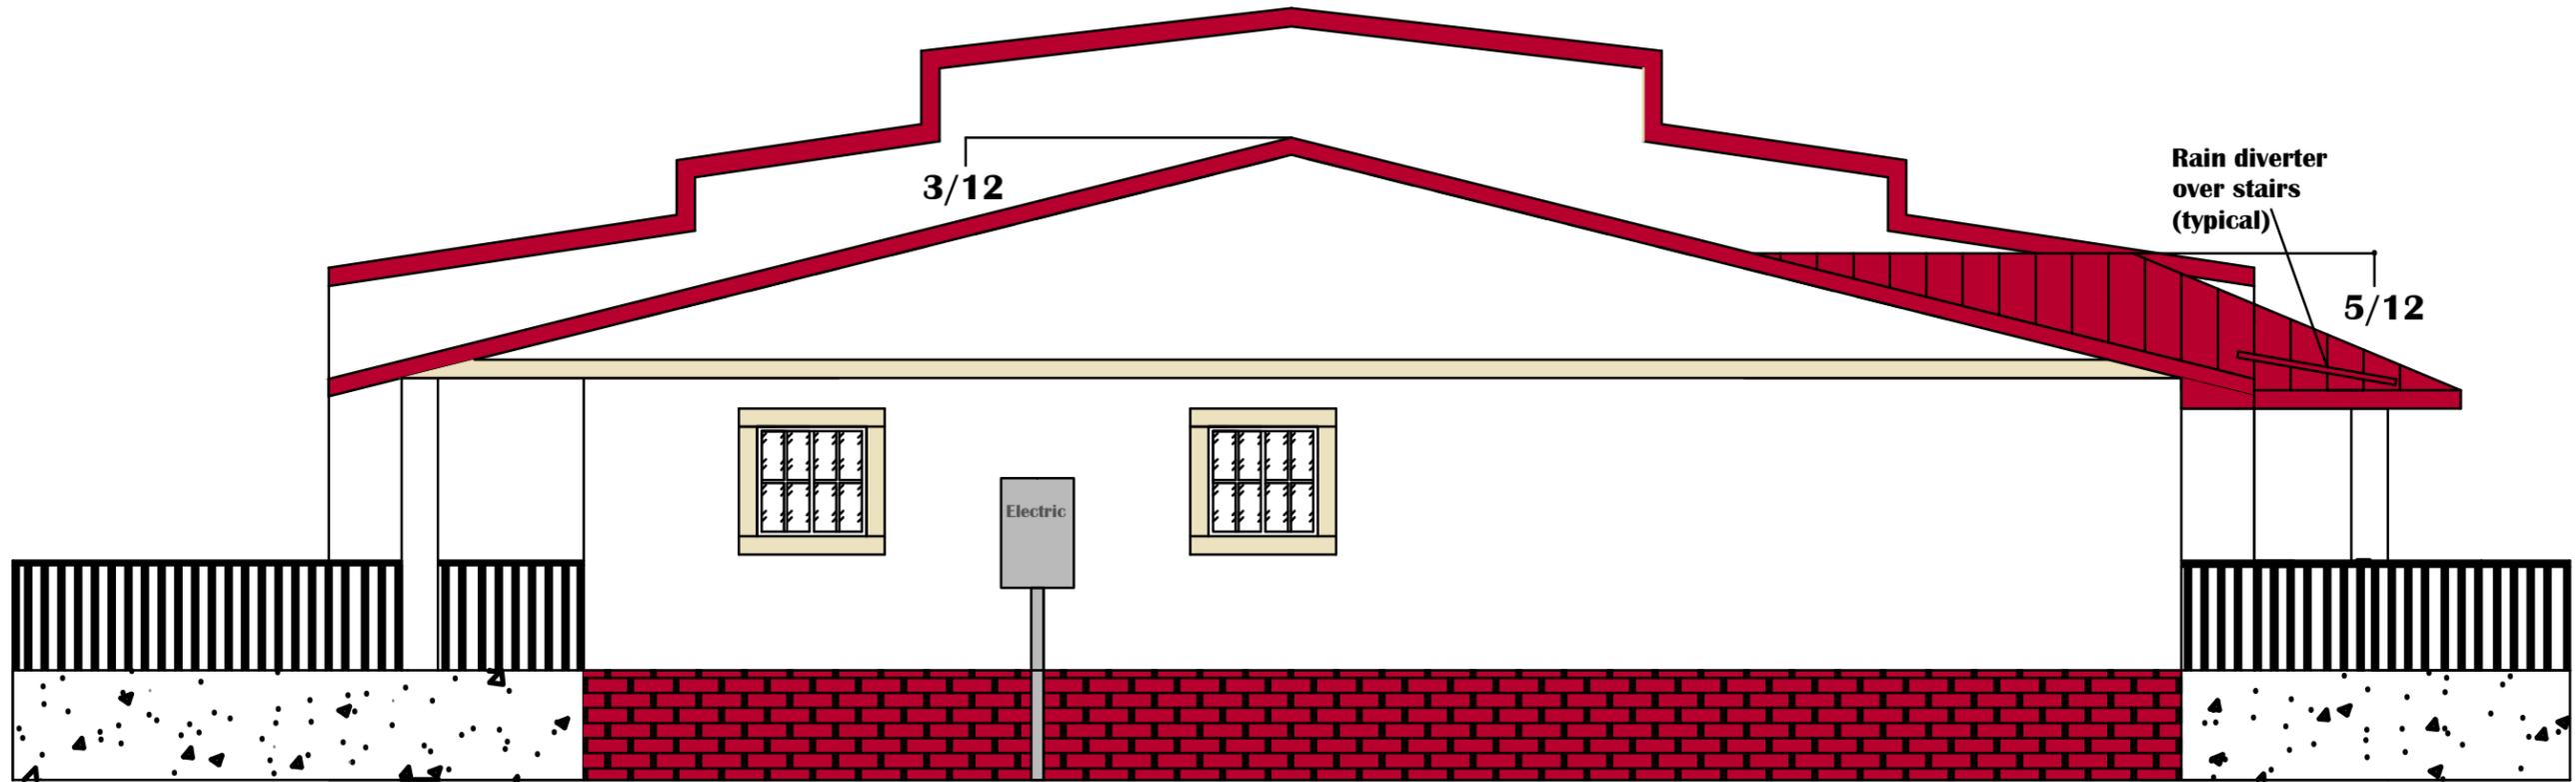

**Drawing is for illustrative purposes only**  
**NTS Measurements are approximate**  
**Vendor shall be responsible for final design**



**FIRE STATION 90 & 104**  
**REAR ELEVATION PLAN**

REVISIONS	
no.	date description


ISSUED FOR: **BIDDING**

Date: 5.23.14  
 Reviewed by: RLB  
 Drawn by: DMGII  
 SHEET NBR.  
**7 of 9**

**24ga (Kynar finish) cap metal on parapet with 6" exposure on front and all edges hemmed**

**24ga standing seam metal roofing w/Kynar finish**

3'-8 9/16"

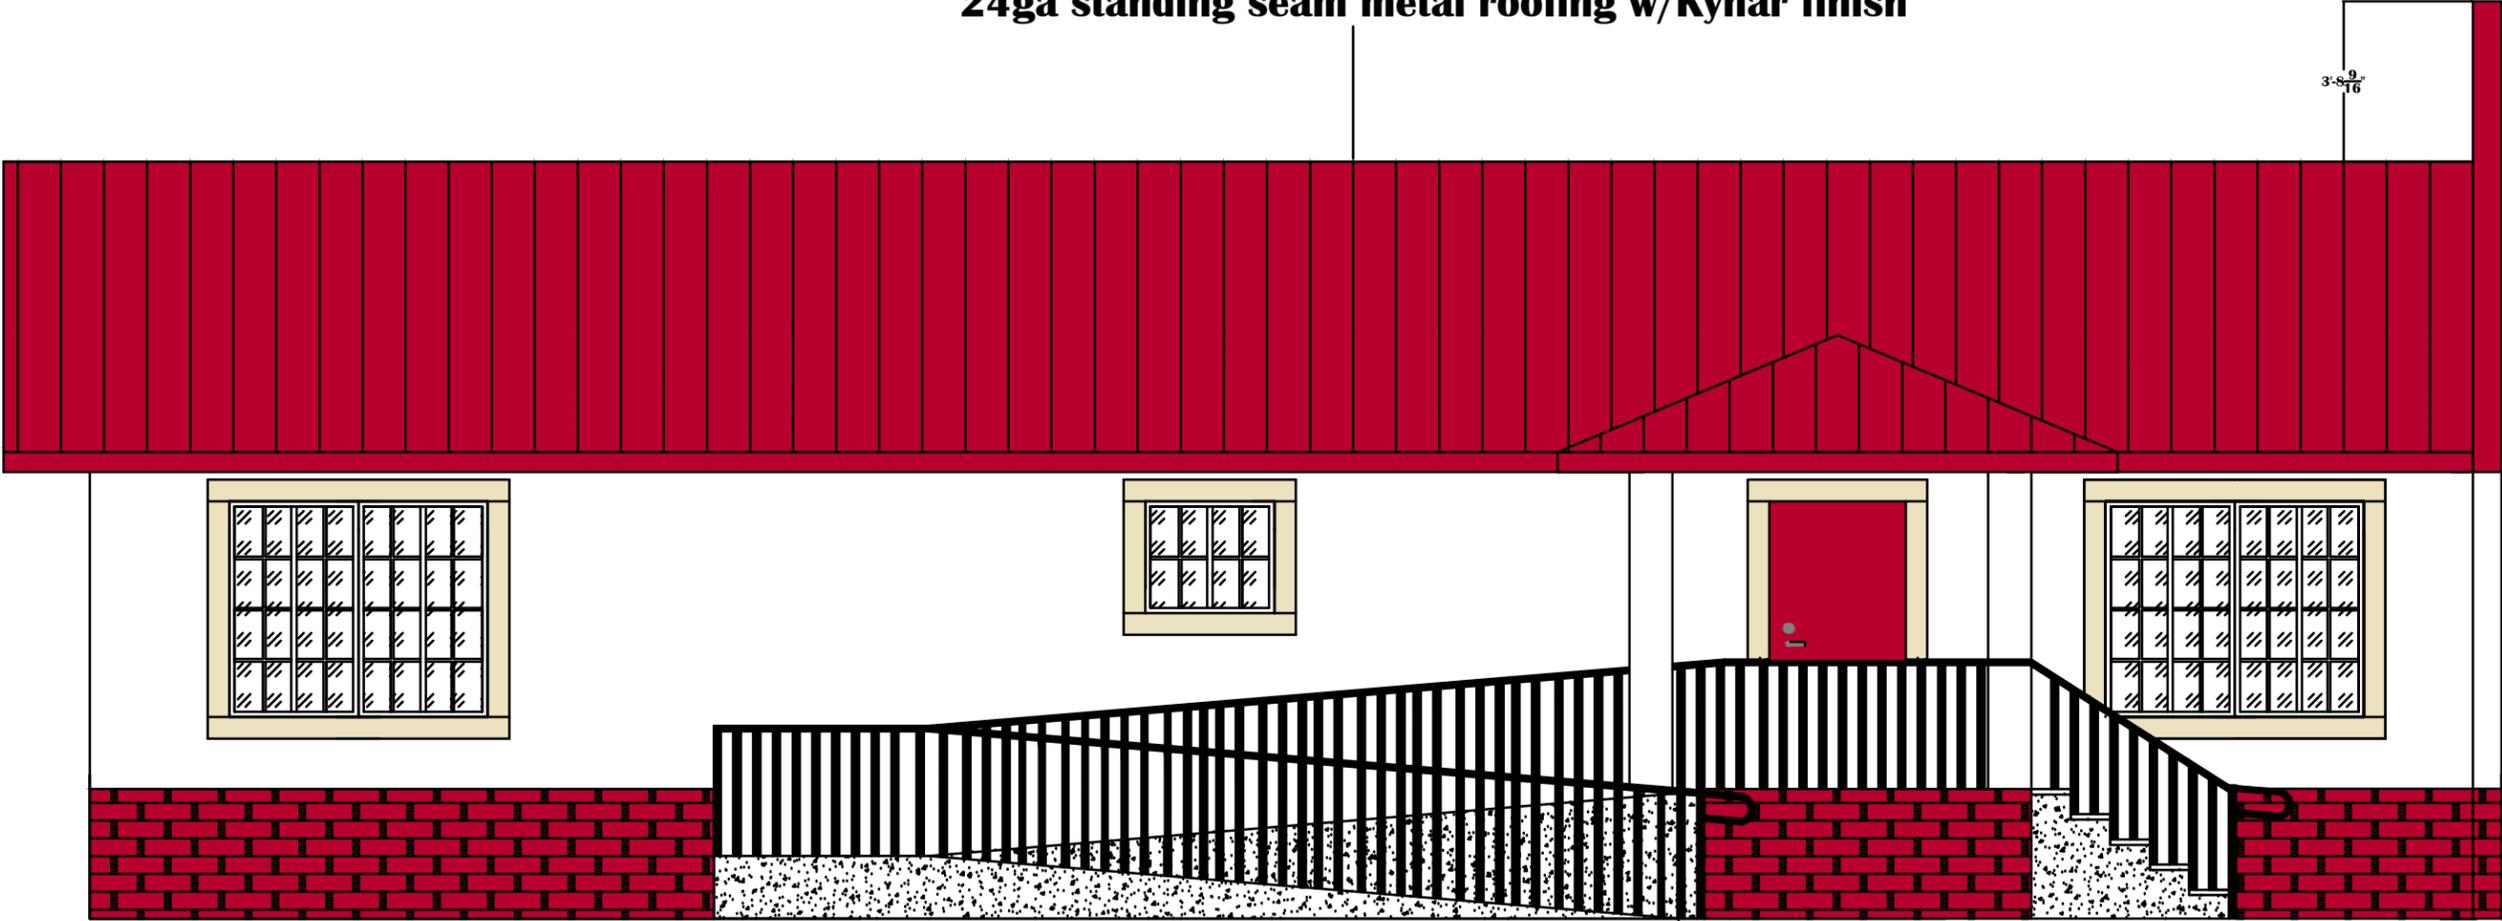

**Drawing is for illustrative purposes only  
 NTS Measurements are approximate  
 Vendor shall be responsible for final design**

**Powder coated aluminum hand and guardrail system (typical)**

**FIRE STATION 90 & 104  
 LEFT SIDE ELEVATION PLAN**

REVISIONS	
no.	date description

ISSUED FOR: **BIDDING**

Date: 5.23.14  
 Reviewed by: RLB  
 Drawn by: DMGII  
 SHEET NBR.

**8 of 9**



**Drawing is for illustrative purposes only**  
**NTS Measurements are approximate**  
**Vendor shall be responsible for final design**

**FIRE STATION 90 & 104**  
**RIGHT SIDE ELEVATION PLAN**

REVISIONS	
no.	date description

ISSUED FOR: **BIDDING**

Date: 5.23.14  
 Reviewed by: RLB  
 Drawn by: DMGII  
 SHEET NBR.  
**9 of 9**